

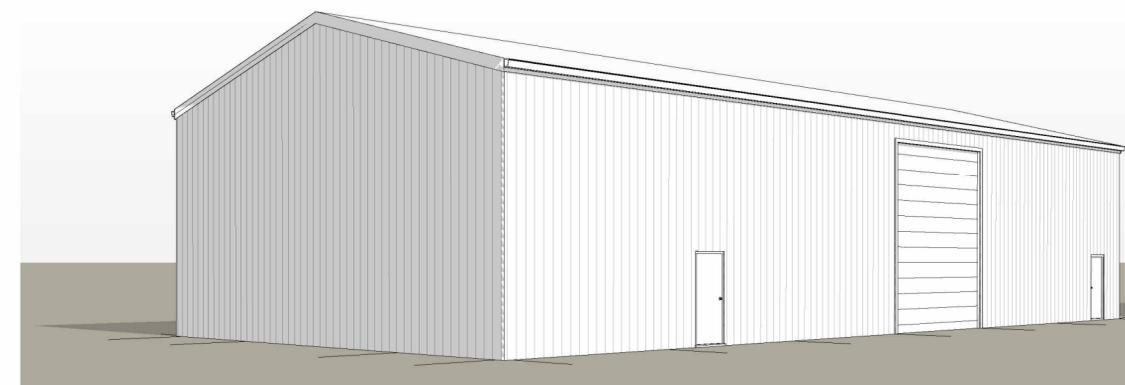
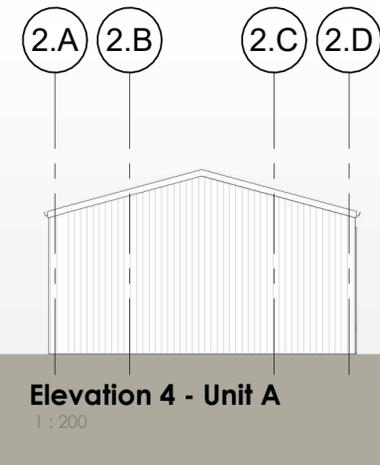
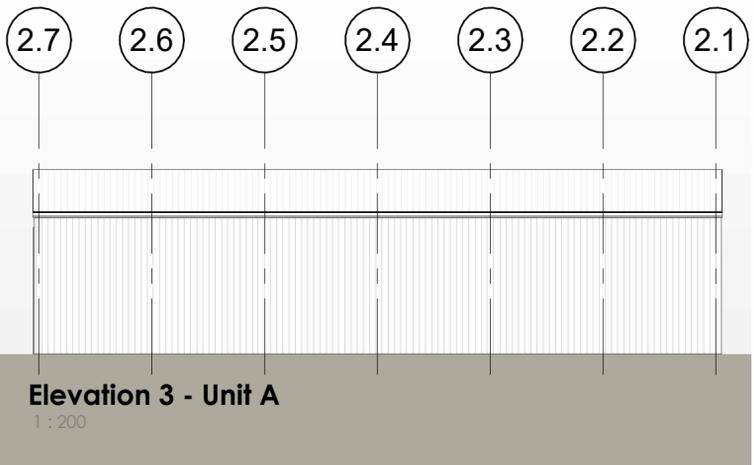


This drawing is the property of Digi Design Co Architecture Ltd. Copyright is reserved by them and the drawing is issued on the condition that it is not used, copied, reproduced, retained or disclosed either wholly or in part, by or to any unauthorised persons, without previous consent in writing of Digi Design Co Architecture Ltd.

ALL DIMENSIONS MUST BE CHECKED PRIOR TO COMMENCING BUILD AND DISCREPNCIES REPORTED BACK TO DDC | STRUCTURAL ENGINEERS DETAILS NOTED ON THIS DRAWING MUST BE CROSS REFERENCED TO THE CALCULATIONS - THE CALCULATIONS TAKE PRECEDNCE OVER INFORMATION DETAILED ON THIS PLAN

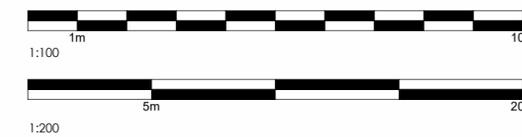

3D View 2

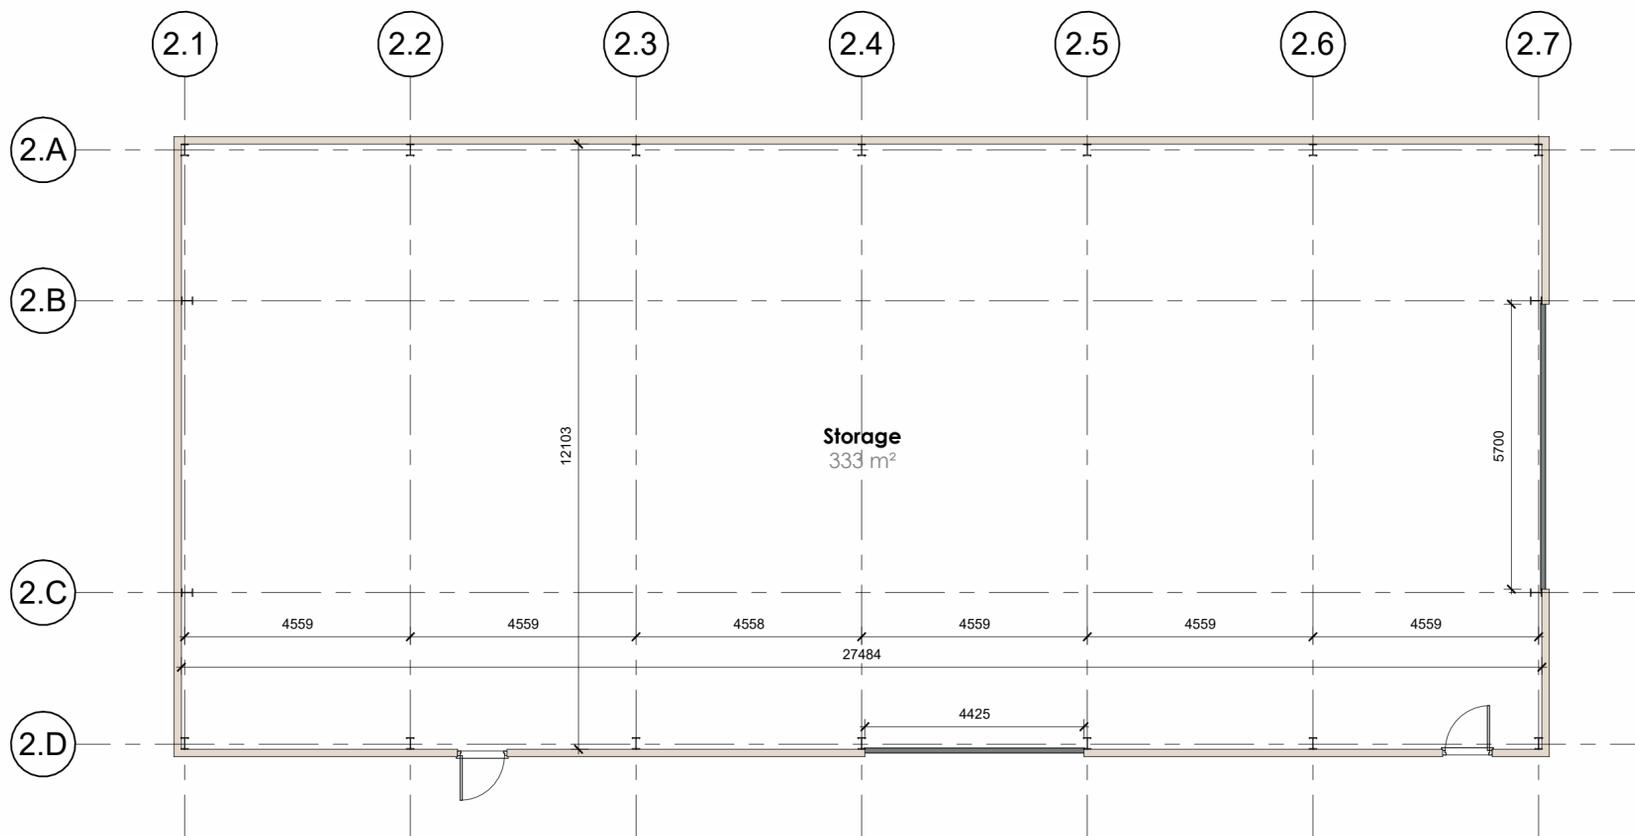

Ground Floor Plan Unit A
1 : 100

NOTE: This planning drawing is an indicative design drawing only and should not be used for construction purposes and is subject to approval from the Local Authority Planning Department.

The Loft, Greenway House, Sugarswell Business Park,
Banbury, Oxfordshire. OX15 6HW.
Tel: +44 (0)1295 267617 | Web: www.digidesignco.com

Client:
Mr S Brackenbury

Project:
Chipping Warden Barns
Appletree Road
Chipping Warden
OX17 1LH

Drawing:
Unit A

Job Number: DDC-2023-888
Scale: As indicated
Date: Date
Sheet: A1

Drawing Number: 001
Drawn By: AJL
Checked: CL

Units: mm