



Elevation 1 - Unit B & C
1 : 200

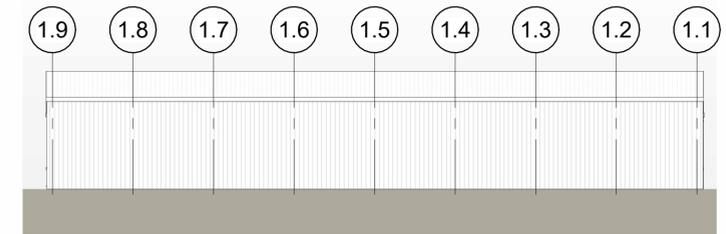


Elevation 2 - Unit B & C
1 : 200



Elevation 3 - Unit B & C
1 : 200

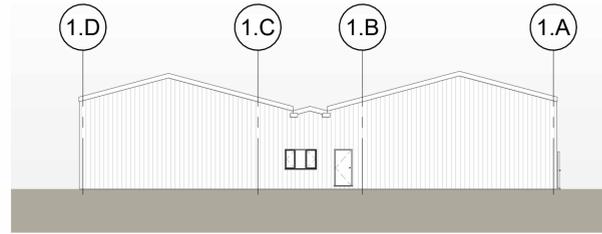

Elevation 4 - Unit B & C
1 : 200

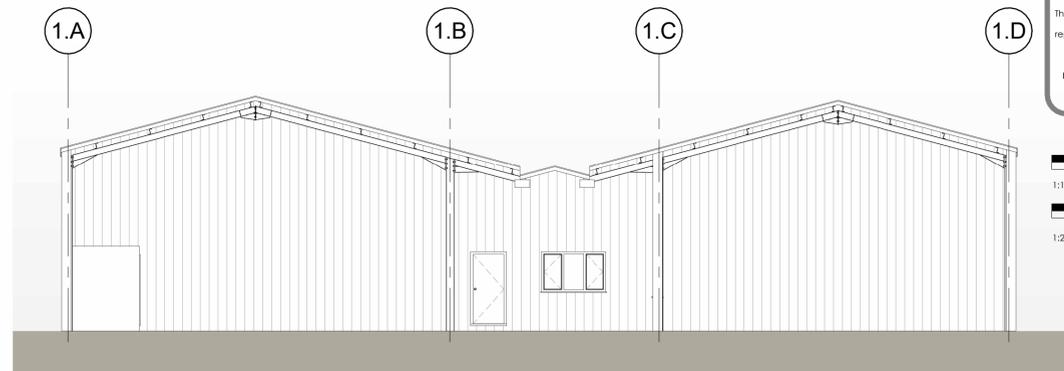


Section Unit B & C
1 : 100

CIAT
CHARTERED PRACTICE

This drawing is the property of Digi Design Co Architecture Ltd. Copyright is reserved by them and the drawing is issued on the condition that it is not used, copied, reproduced, retained or disclosed either wholly or in part, by or to any unauthorised persons, without previous consent in writing of Digi Design Co Architecture Ltd.


ALL DIMENSIONS MUST BE CHECKED PRIOR TO COMMENCING BUILD AND DISCREPANCIES REPORTED BACK TO DDC | STRUCTURAL ENGINEERS DETAILS NOTED ON THIS DRAWING MUST BE CROSS REFERENCED TO THE CALCULATIONS - THE CALCULATIONS TAKE PRECEDENCE OVER INFORMATION DETAILED ON THIS PLAN

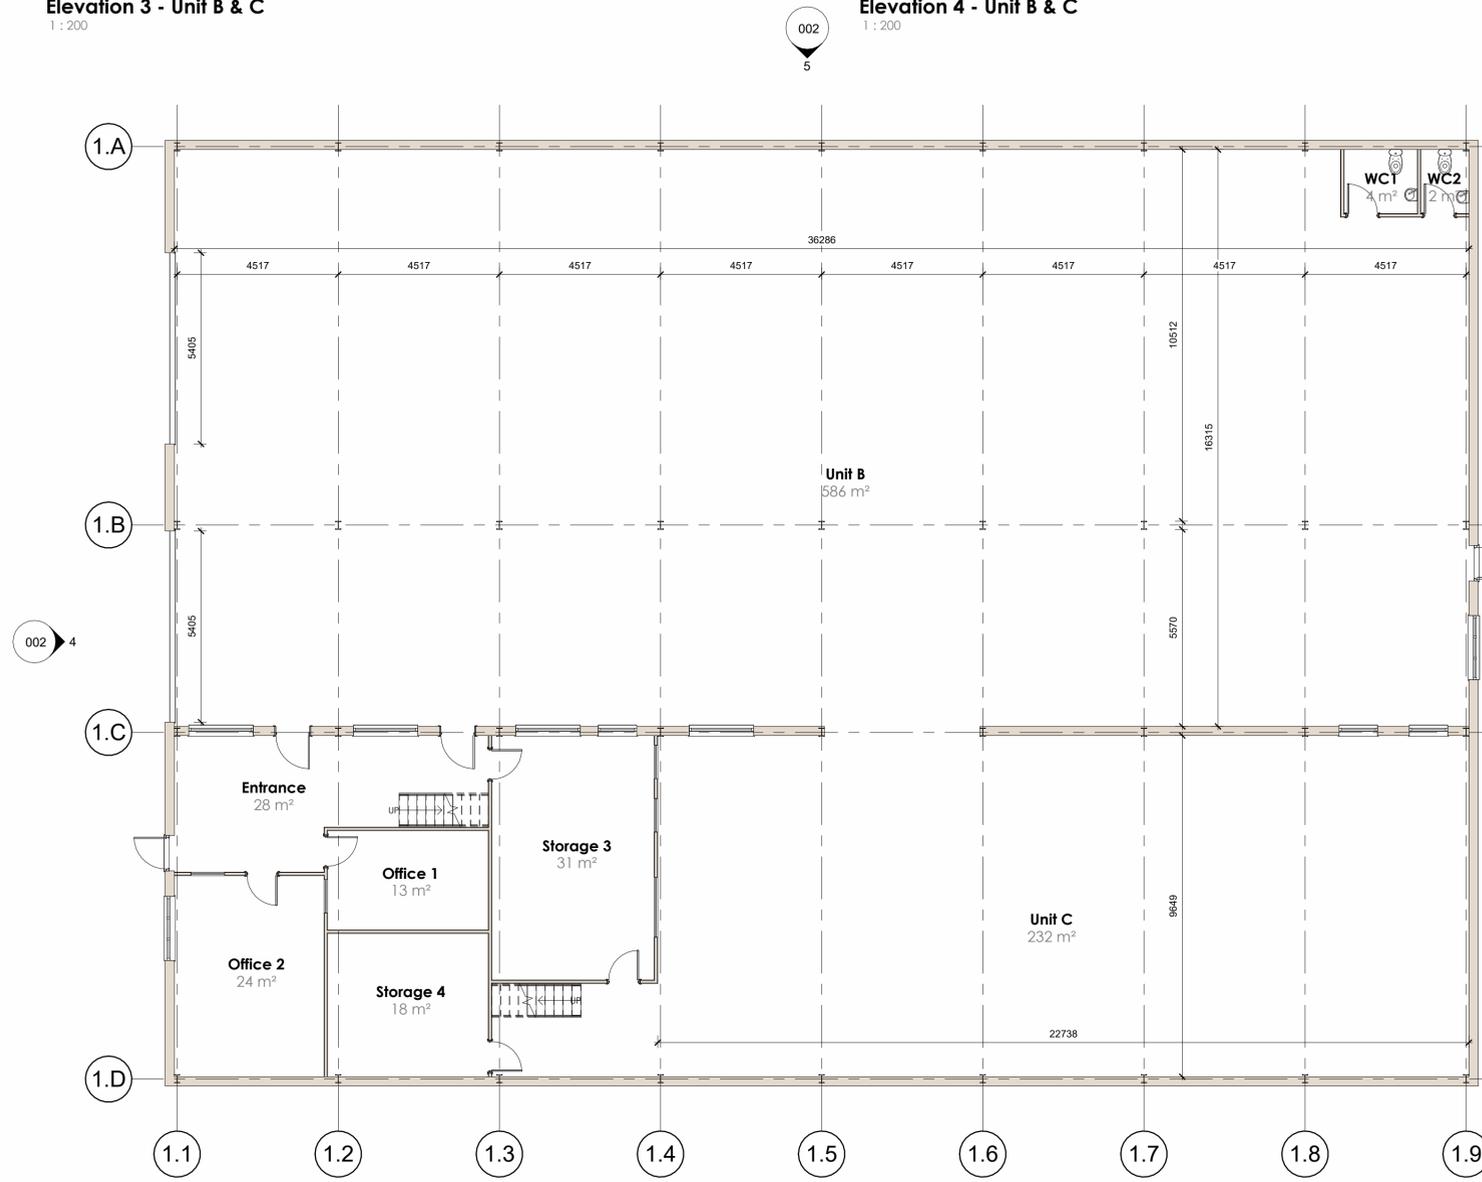

Ground Floor Plan Unit B & C
1 : 100



3D View 1

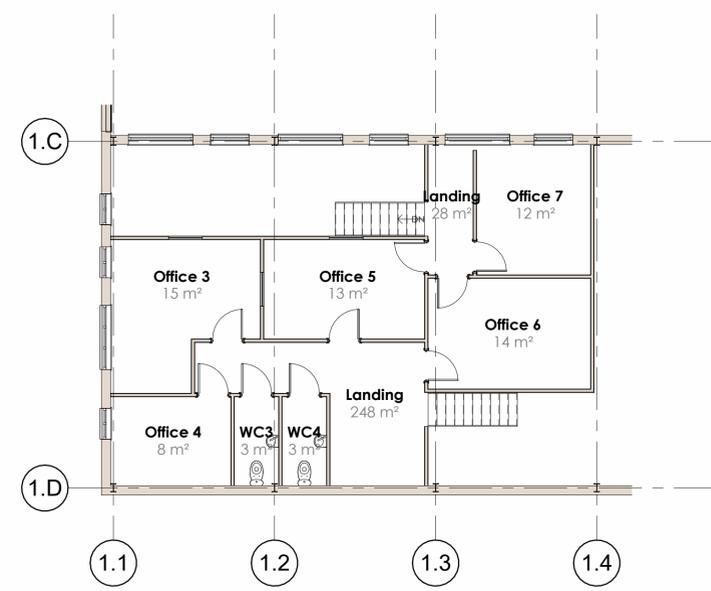

First Floor Plan Unit 1
1 : 100

- SUBJECT TO BUILDING CONTROL APPROVAL -
CONTRACTOR TO CONTACT D.D.C. PRIOR TO COMMENCEMENT OF PROJECT FOR KICK OFF MEETING ON SITE

ddc
architecture
The Loft, Greenway House, Sugarswell Business Park, Banbury, Oxfordshire. OX15 6HW. Tel: +44 (0)1295 267617 | Web: www.digidesignco.com

Client:
Mr S Brackenbury

Project:
**Chipping Warden Barns
Appletree Road
Chipping Warden
OX17 1LH**

Drawing:
Unit B & C

Job Number: DDC-2023-888	Scale: As Indicated	Date:	Sheet: A1
-----------------------------	------------------------	-------	--------------

Drawing Number: 002	Drawn By: AJL	Checked: CL
-------------------------------	------------------	----------------

Units:
mm