
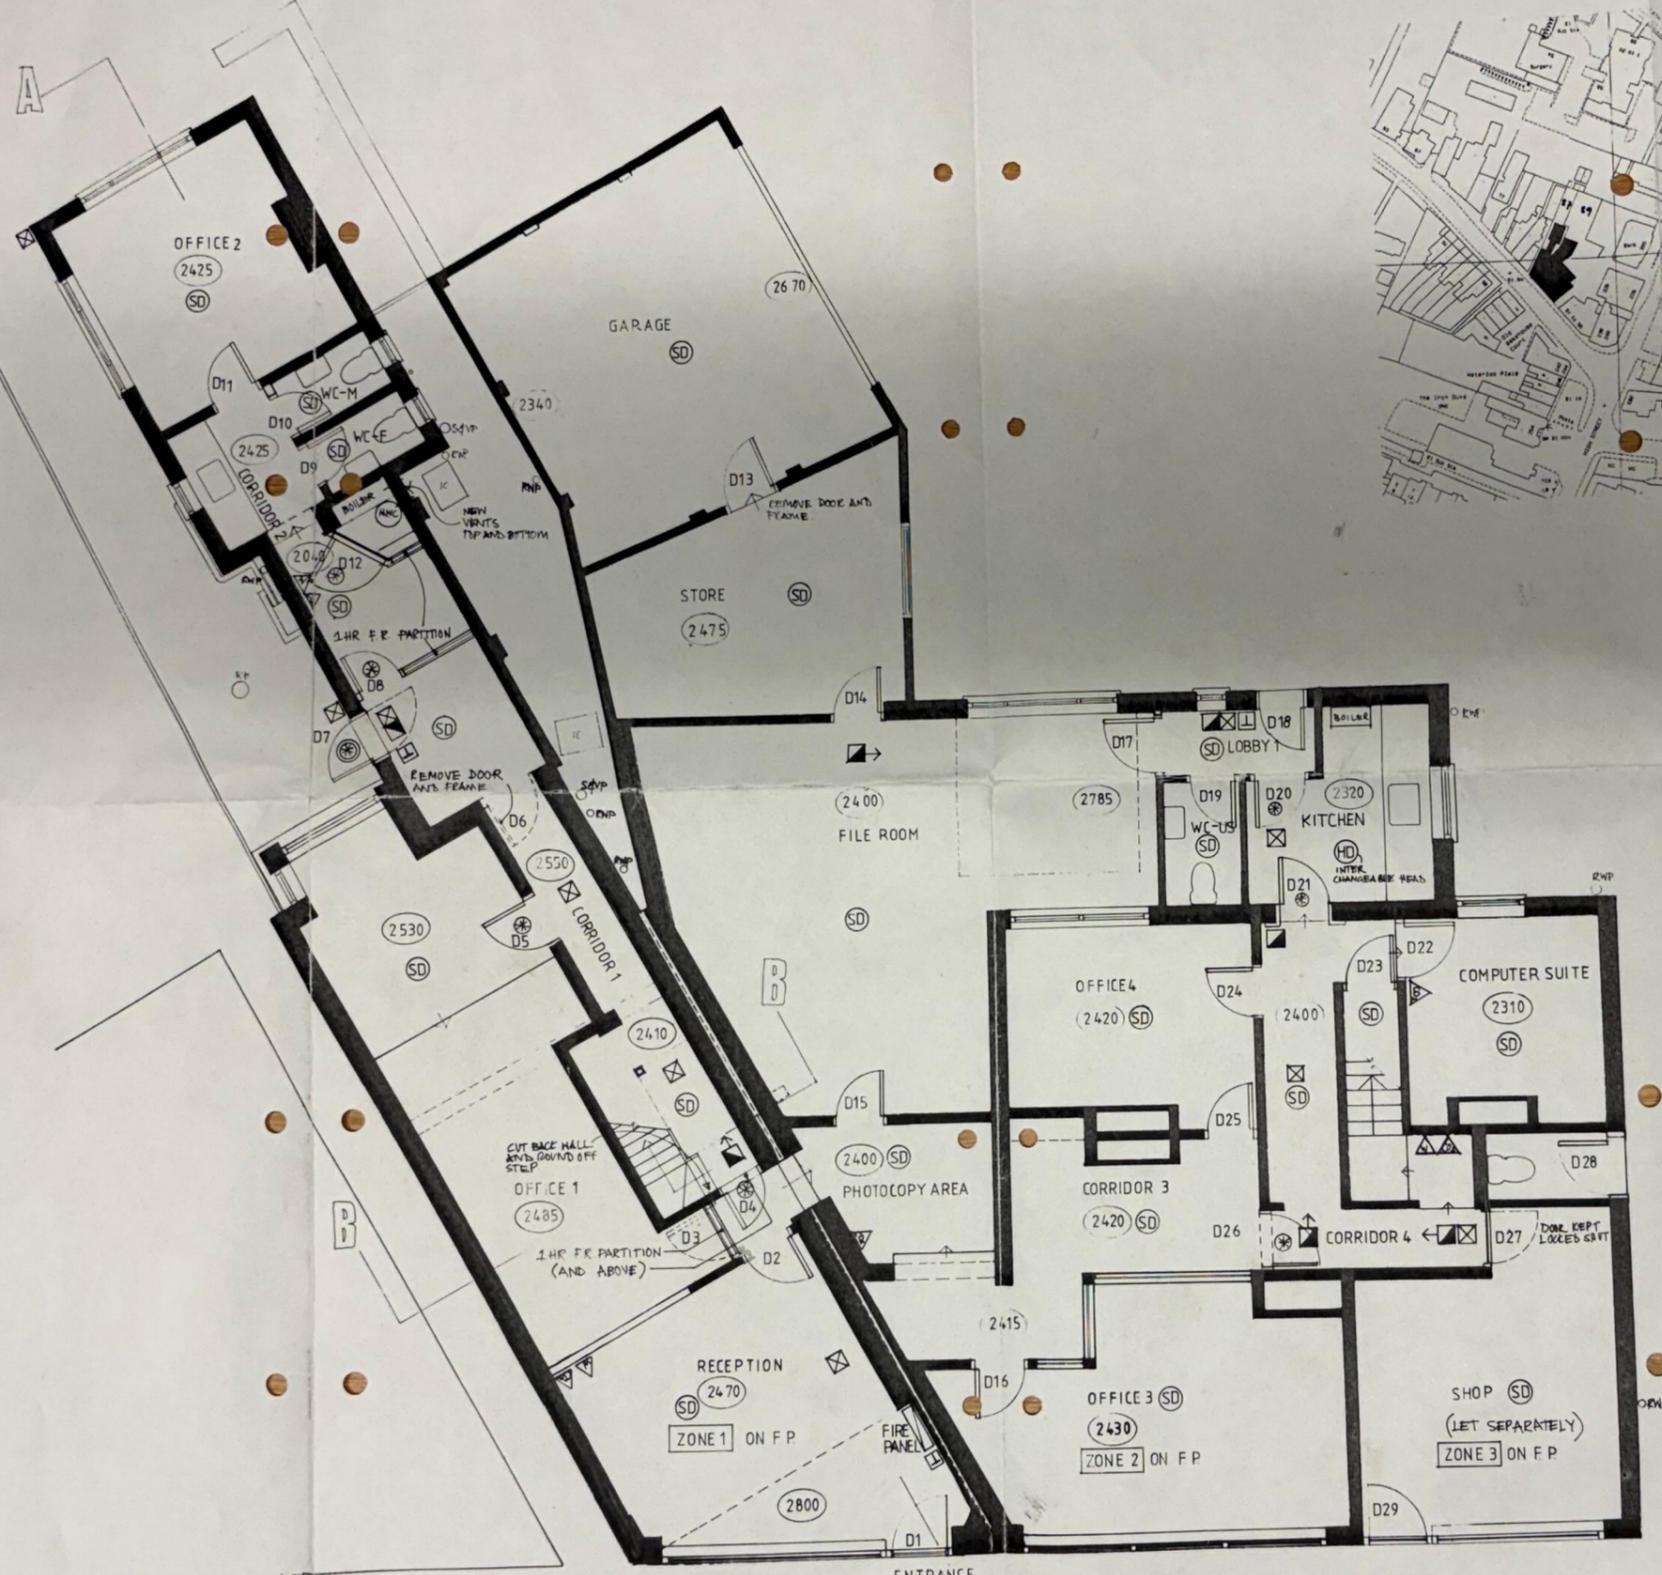


LOCATION PLAN 1:1250

REPRODUCED UNDER LICENCE NO. AL 100034803

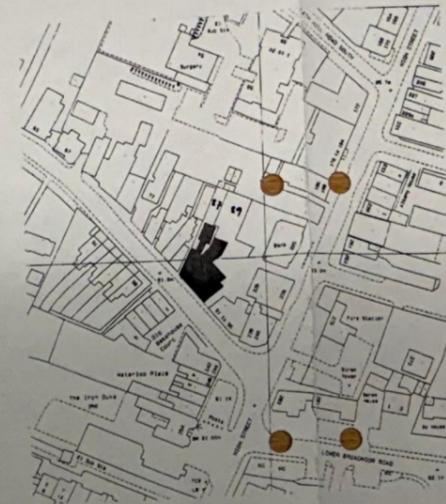

BUILDING 1 (87)

BUILDING 2 (89)

NOTES
All dimensions must be checked on site and not scaled from this drawing

LEGEND

- 1hr F.R. PARTITION
100x50 SW STUDS AT 400 CTRS NOGGINGS AT 600CTRS LINED WITH 100MM SOUND RESISTANT QUILT FACED BOTH SIDES IN 12.5MM FIRELINE PLASTER BOARD AND SKIM COAT PLASTER
- 1/2 HR FIRE DOOR WITH VISION PANELS ELECTRICALLY RETAINED AND OPERATED VIA FIRE ALARM SYSTEM
- EXTERNAL 1HR FIRE DOOR
- FIRE EXIT SIGN
- ILLUMINATED FIRE EXIT SIGN
- EMERGENCY LIGHTING
- BREAK GLASS
- ZONED FIRE PANEL
- WATER FIRE EXTINGUISHER
- DRY POWDER EXTINGUISHER
- CO2 EXTINGUISHER
- SMOKE DETECTOR
- HEAT DETECTOR

CLB 22.7.01

Date	Revisions

© copyright
Ochre Design Associates
13, Nine Acres
June Lane
Midhurst
West Sussex
GU29 9EP

Client
Parry Kirkby Blackwell


Job Title
**Beechey House
87 Church Street
Crowthorne
Berkshire
RG45 7AW**

Drawing Title
**GROUND FLOOR PLAN
BUILDING REGULATIONS**

Scale
SCALE 1:50

Date **20.7.01** Drawn by **CLB**

Drwg No
PKB 05.01-07

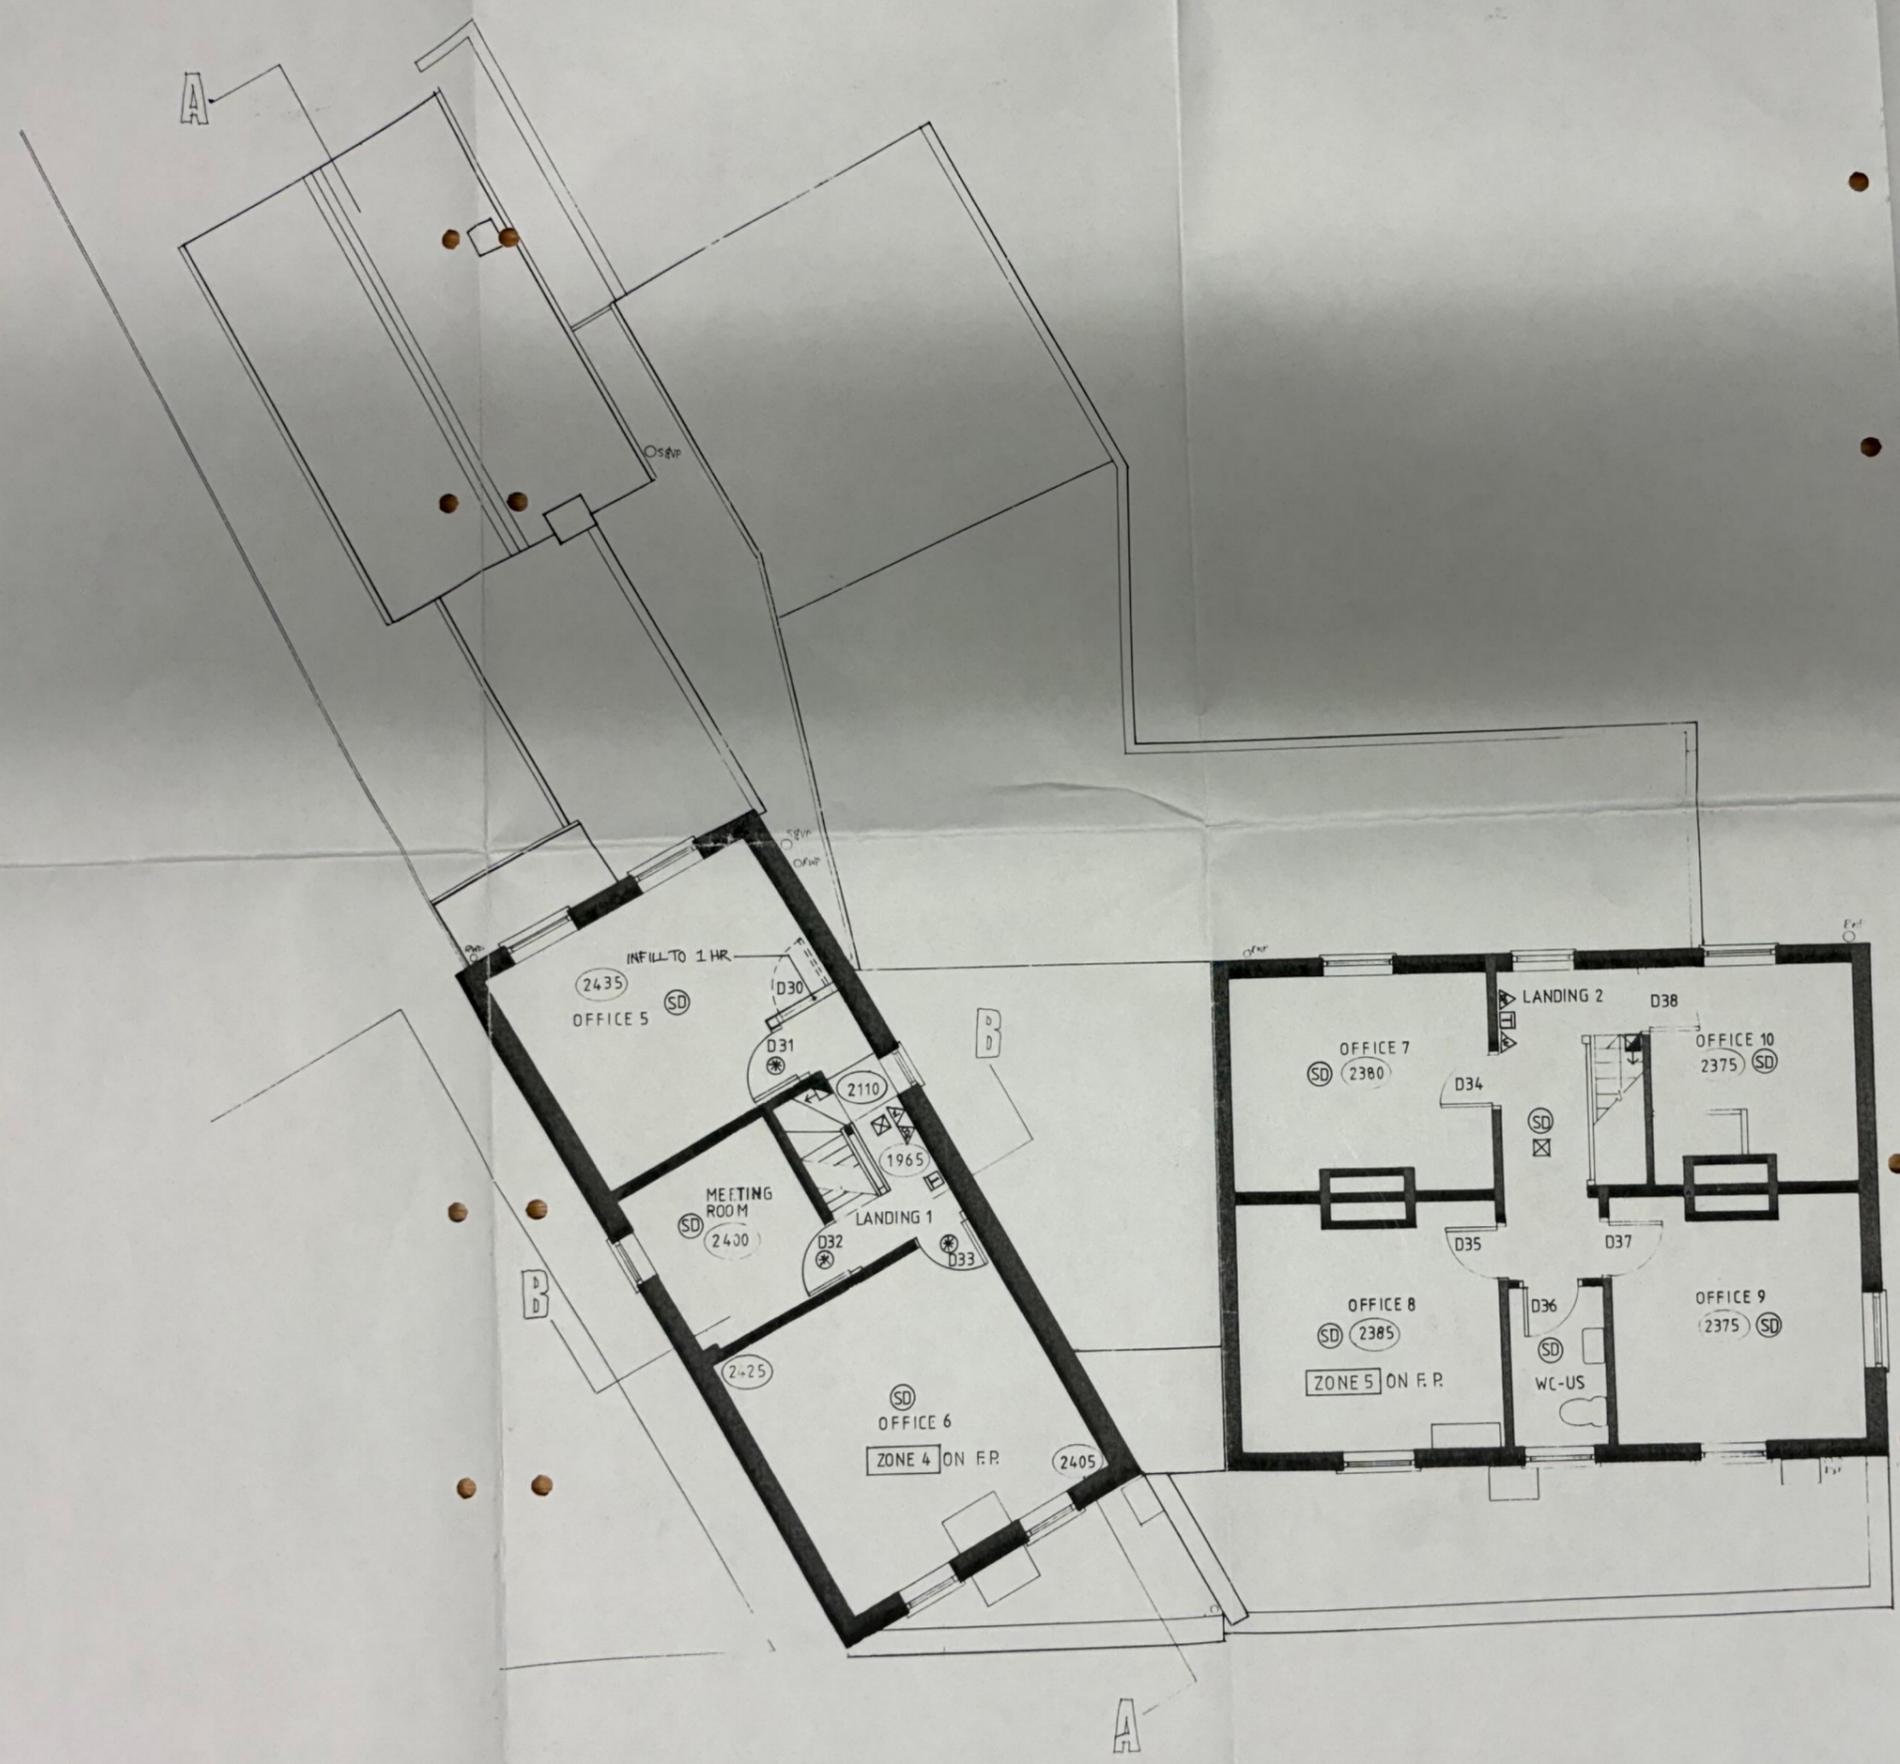

NOTES
 All dimensions must be checked on site and not scaled from this drawing

LEGEND

- 1hr F.R. PARTITION
 100x50 SW STUDS AT 400 CTRS NOGGINGS AT 600CTRS LINED WITH 100MM SOUND RESISTANT QUILT FACED BOTH SIDES IN 12.5MM FIRELINE PLASTER BOARD AND SKIM COAT PLASTER
- ⊗ 1/2 HR FIRE DOOR WITH VISION PANELS ELECTRICALLY RETAINED AND OPERATED VIA FIRE ALARM SYSTEM
- ⊙ EXTERNAL 1HR FIRE DOOR
- ⬛ FIRE EXIT SIGN
- ⊗ ILLUMINATED FIRE EXIT SIGN
- ⊗ EMERGENCY LIGHTING
- ⊗ BREAK GLASS
- ⊗ ZONED FIRE PANEL
- ⊗ WATER FIRE EXTINGUISHER
- ⊗ DRY POWDER EXTINGUISHER
- ⊗ CO2 EXTINGUISHER
- ⊙ SMOKE DETECTOR
- ⊙ HEAT DETECTOR

Handwritten signature 22.7.01

A	Date	Revisions

Ochre Design Associates
 13, Nine Acres
 June Lane
 Midhurst
 West Sussex
 GU29 9EP

Client
Parry Kirkby Blackwell


Job Title
**Beechey House
 87 Church Street
 Crowthorne
 Berkshire
 RG45 7AW**

Drawing Title
**FIRST FLOOR PLAN
 BUILDING REGULATIONS**

Scale **SCALE 1:50**

Date **20.7.01** (Drawn by **CLB**)

Drw No **PKB 05.01-08** Rev.

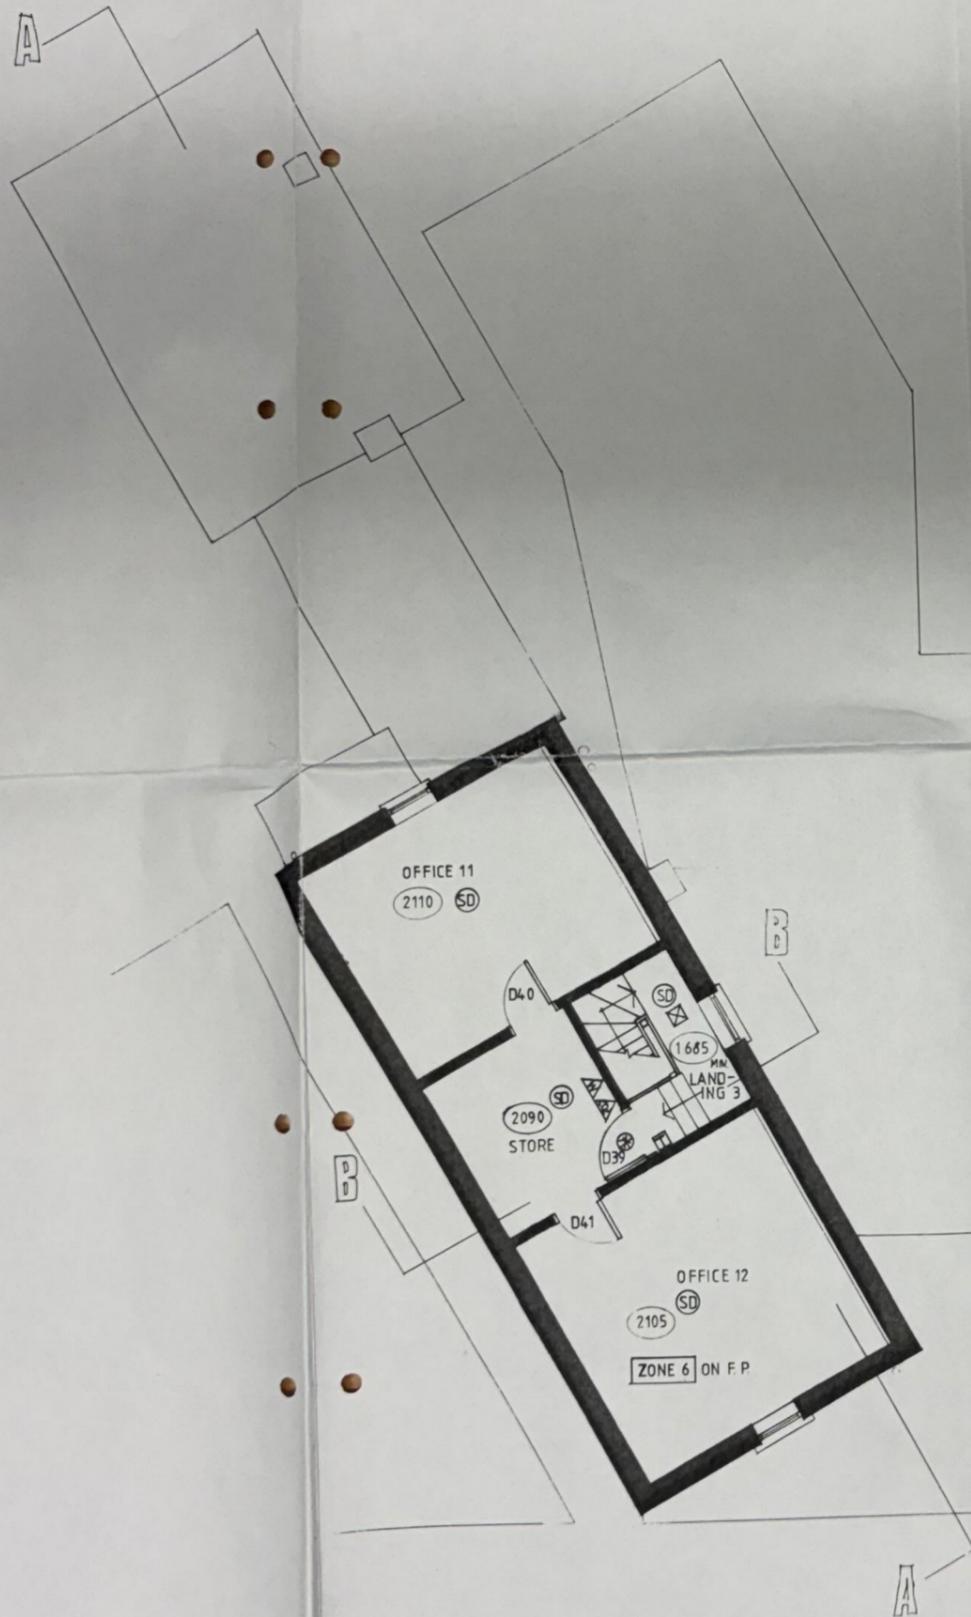

NOTES
 All dimensions must be checked on site and not scaled from this drawing

LEGEND

- 1hr F.R. PARTITION
 100x50 SW STUDS AT 400 CTRS NOGGINGS AT 600CTRS LINED WITH 100MM SOUND RESISTANT QUILT FACED BOTH SIDES IN 12.5MM FIRELINE PLASTER BOARD AND SKIM COAT PLASTER
- ⊗ 1/2 HR FIRE DOOR WITH VISION PANELS ELECTRICALLY RETAINED AND OPERATED VIA FIRE ALARM SYSTEM
- ⊙ EXTERNAL 1HR FIRE DOOR
- ⊠ FIRE EXIT SIGN
- ⊠ ILLUMINATED FIRE EXIT SIGN
- ⊠ EMERGENCY LIGHTING
- ⊠ BREAK GLASS
- ⊠ ZONED FIRE PANEL
- ⊠ WATER FIRE EXTINGUISHER
- ⊠ DRY POWDER EXTINGUISHER
- ⊠ CO2 EXTINGUISHER
- ⊙ SMOKE DETECTOR
- ⊙ HEAT DETECTOR

Handwritten signature and date: 22.7.01

A	Date	Revisions

© copyright
Ochre Design Associates
 13, Nine Acres
 June Lane
 Midhurst
 West Sussex
 GU29 9EP

Client
Parry Kirkby Blackwell

Job Title
Beechey House
 87 Church Street
 Crowthorne
 Berkshire
 RG45 7AW

Drawing Title
SECOND FLOOR PLAN
BUILDING REGULATIONS

Scale **SCALE 1:50**

Date **20.7.01** Drawn by **CLB**

Drwg No. **PKB 05.01-09** Rev.