

planting within  
1200 dia pre-cast  
concrete containers



LOCATION OF EXG DETACHED  
BUILDING TO BE DEMOLISHED

NEW RETAINING WALL TO STRUCT  
ENG DETAILS WITH BITUTHENE  
TANKING TO SEPARATE DETAIL

TWYFORDS DOC M SANITARYWARE  
PACK WITH NEW SVP CONNECTION  
AND BELOW GROUND DRAINAGE

NEW RETAINING  
WALL TO STRUCT  
ENG DETAILS WITH  
BITUTHENE TANKING  
TO SEPARATE  
DETAIL

NEW FLOOR GULLY  
TO CONNECT TO  
EXG DRAINAGE

NEW RC SLAB WITH SMOOTH FLOAT  
FINISH TO BE AT SAME LEVEL AS  
EXISTING

SVP'S AND WVP'S  
FROM ABOVE - FINAL POSITIONS TO  
BE DETERMINED ON COMPLETION  
OF DRAINAGE LAYOUT

RETAIL  
UNIT

NEW STEEL COL AND FOUNDATION  
TO STRUCT ENG DETAIL

PARLIAMENT ST

*Handwritten signature:*  
W. J. ...



TITLE NUMBER  
NYK273329




NORTH YORKSHIRE : HARROGATE

ORDNANCE SURVEY MAP REFERENCE: SE3055SW

SCALE: 1:1250

CROWN COPYRIGHT. Produced by HMLR. Further reproduction in whole or in part is prohibited without the prior written permission of Ordnance Survey. Licence Number GD272728.

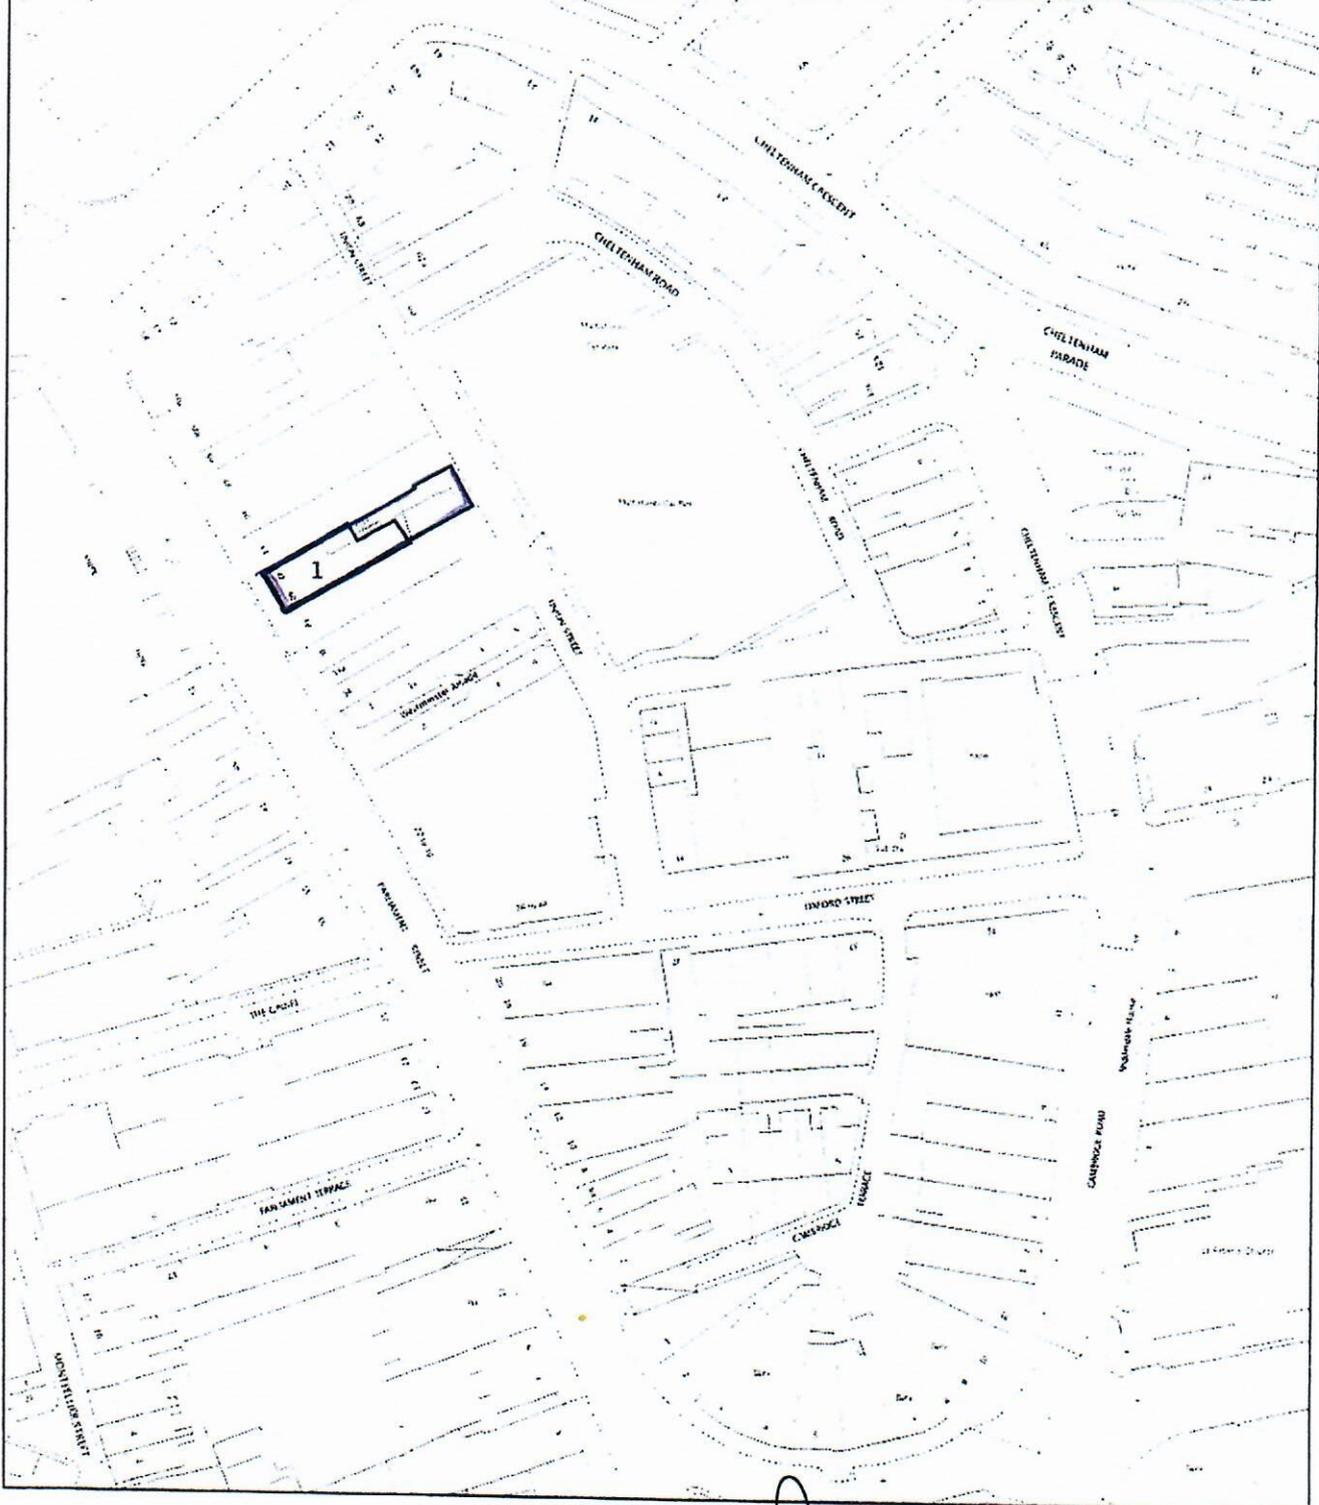

*[Handwritten signature]*



This title is dealt with by Land Registry, York Office.

This is a print of the view of the title plan obtained from HM Land Registry showing the state of the title plan on 28 MAR 2006 at 10:10:10. It may not be to the scale shown on the title plan.