



## 6 NEW BRIDGE STREET

1<sup>ST</sup> FLOOR DESIGN CONCEPT RP2331DC01 20.05.22

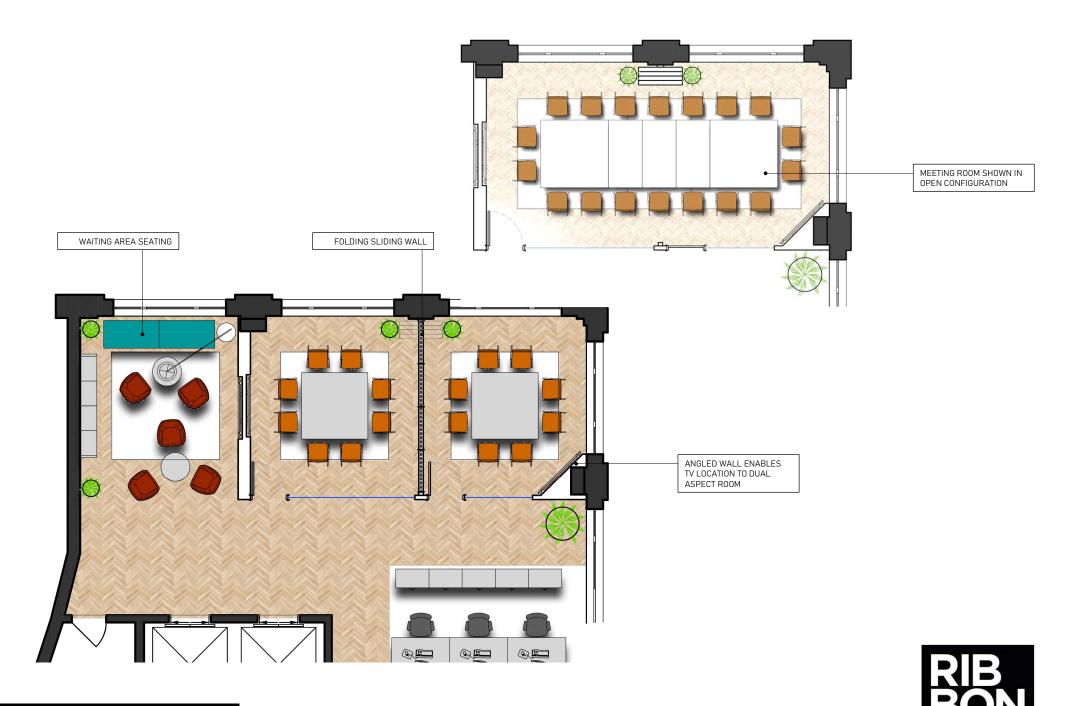

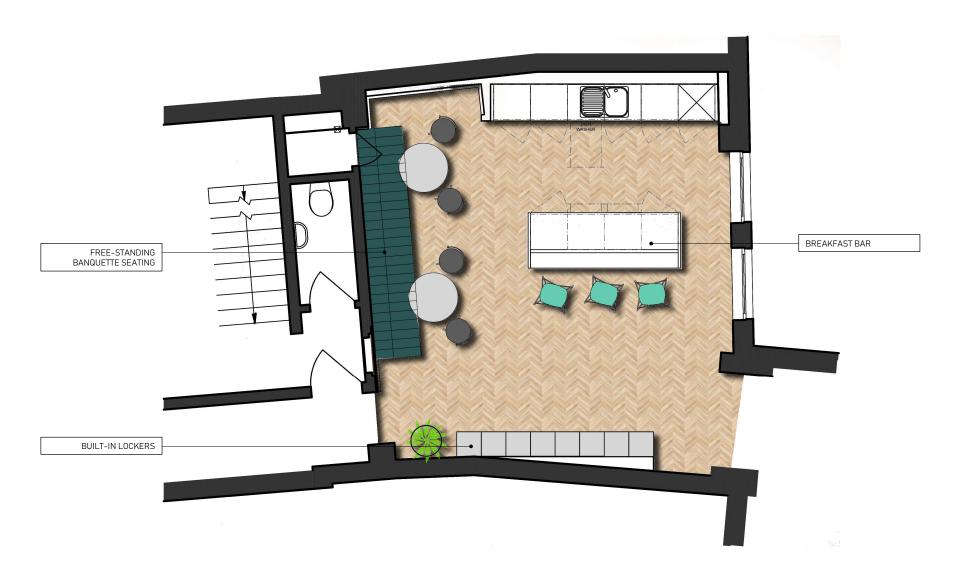
























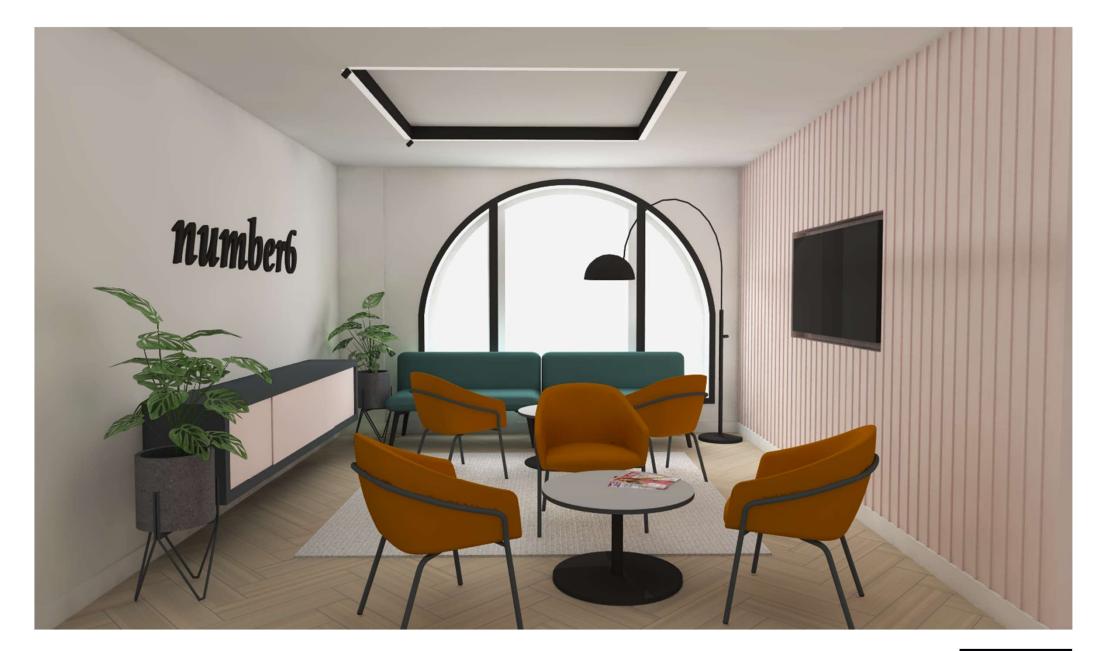



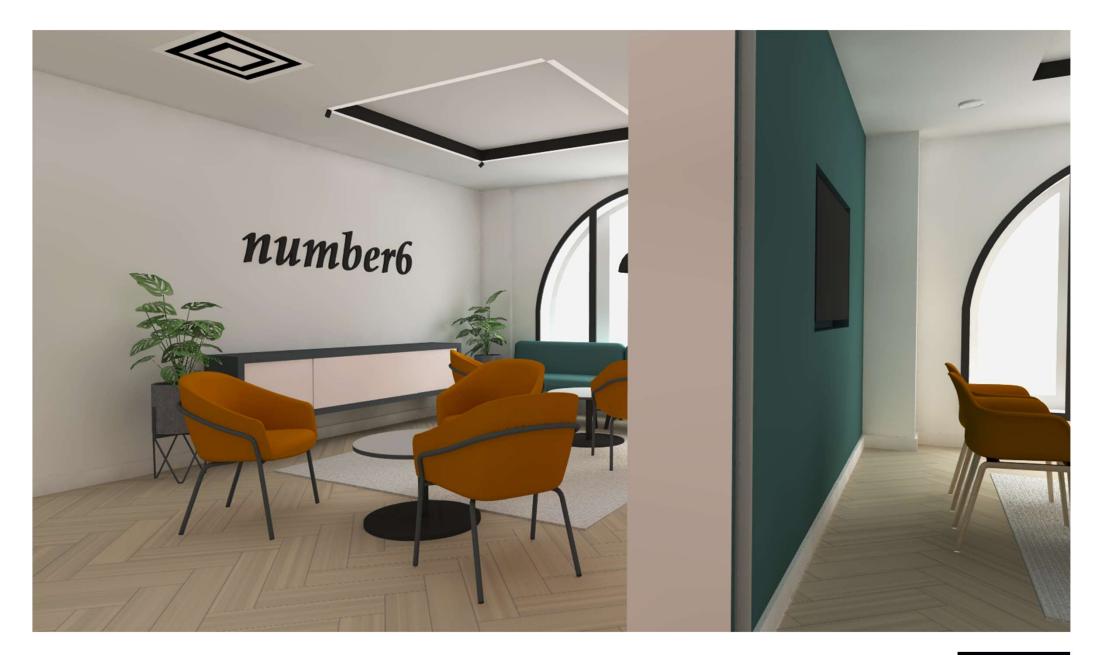



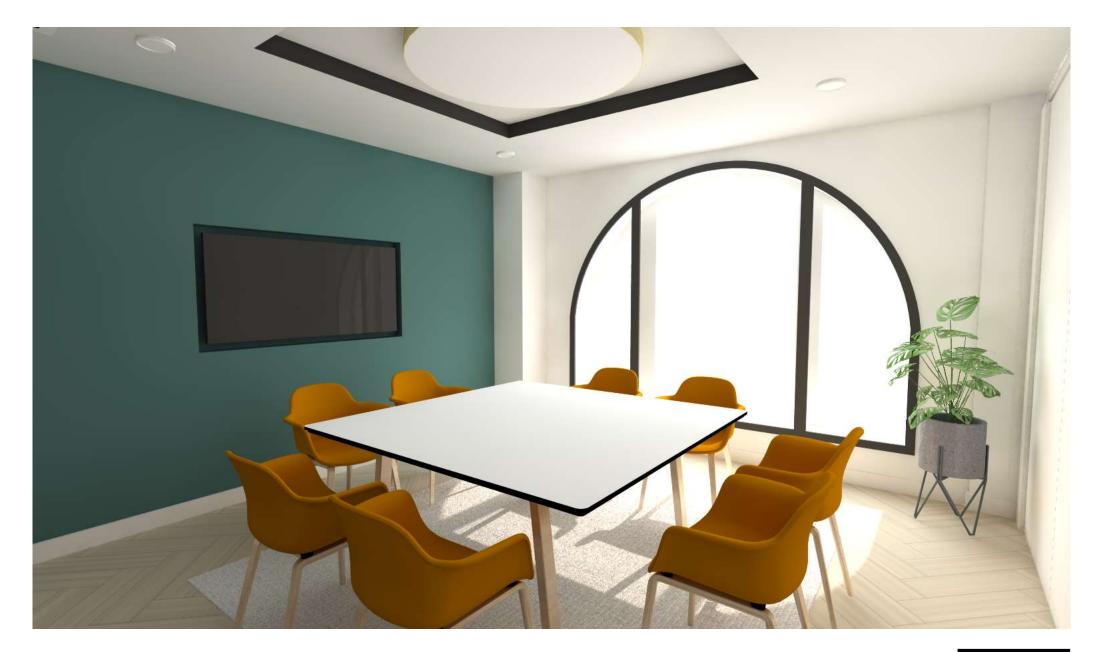












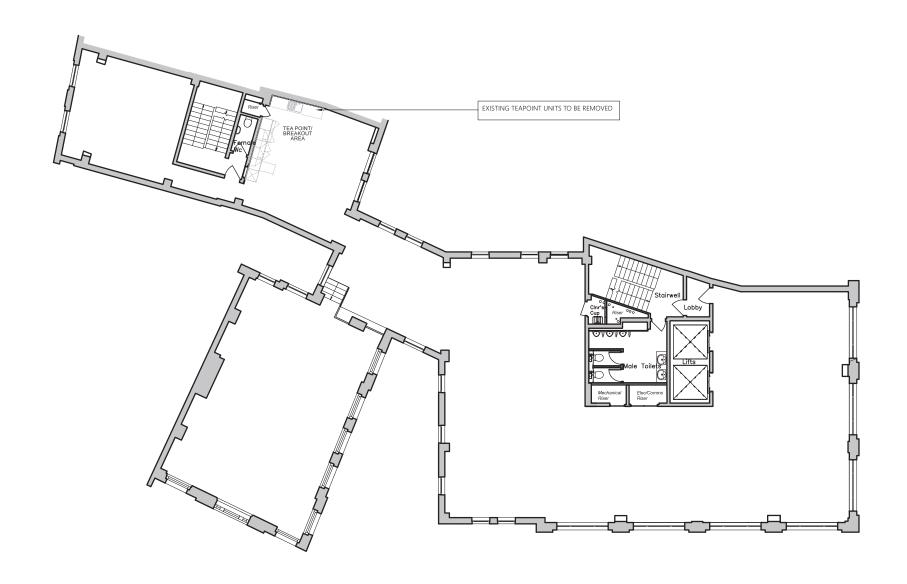

DRAWING TITLE
EXISTING FLOOR PLAN CLIENT 6NBS PROJECT NUMBER DRAWING NUMBER FIRST FLOOR
6 NEW BRIDGE STREET RP2331 EX\_GA

FOR INFORMATION


1:100 @ A2 20.05.22 B

**EXISTING FLOOR PLAN** 

LONDON

SCALE

DATE

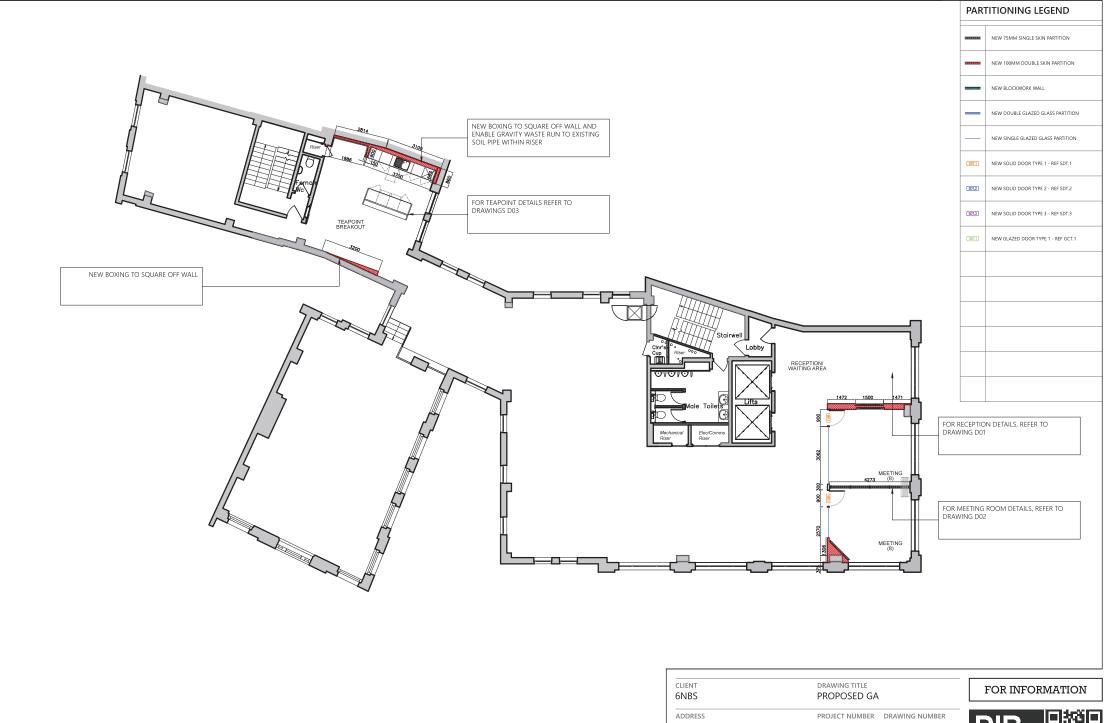


PROPOSED GENERAL ARRANGEMENT

FIRST FLOOR 6 NEW BRIDGE STREET LONDON

RP2331 PR\_GA

DATE SCALE 1:100 @ A2 20.05.22 B

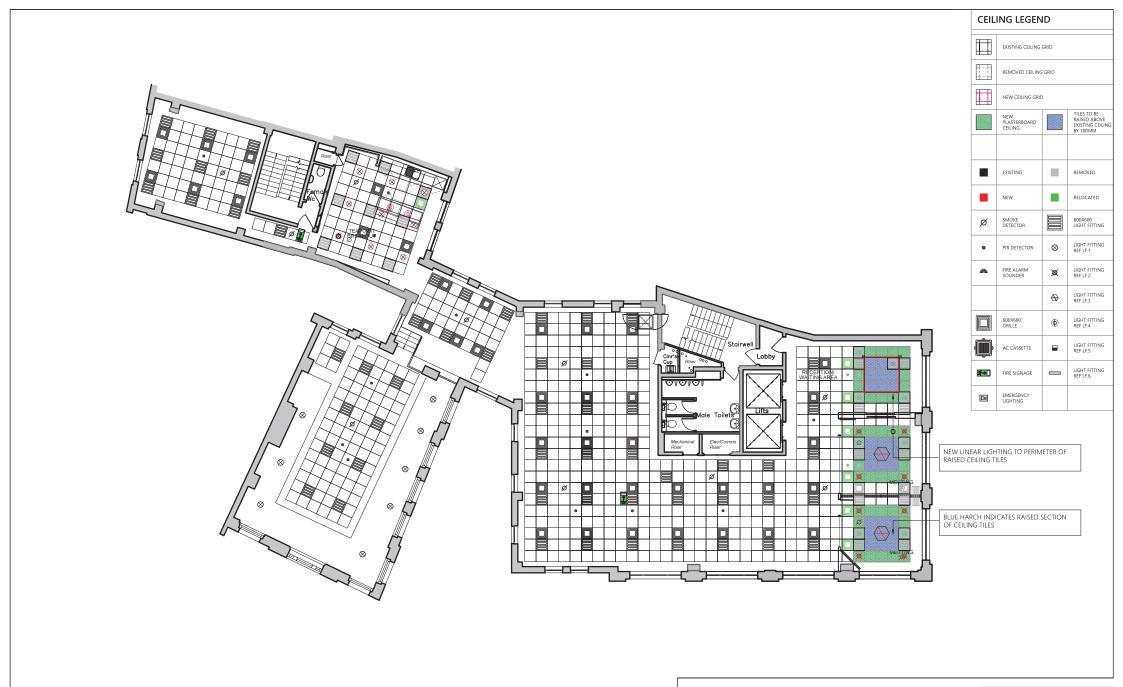

PROPOSED REFLECTED CEILING PLAN

CLIENT DRAWING TITLE
6NBS PROPOSED R

NBS PROPOSED REFLECTED CEILING

FIRST FLOOR
6 NEW BRIDGE STREET
LONDON

PROJECT NUMBER DRAWING NUMBER RP2331 PR\_RC


SCALE DATE REVISION 1:100 @ A2 20.05.22 B

RIB

FOR INFORMATION

02071 830 780 PIRRONIPRO IECTS

NOTE: DRAWING SUBJECT TO STATUTORY APPROVAL. DRAWING SHOULD NOT BE SCALED FROM: ALL DIMENSIONS SHOWN IN MM UNLESS OTHERWISE SHOW

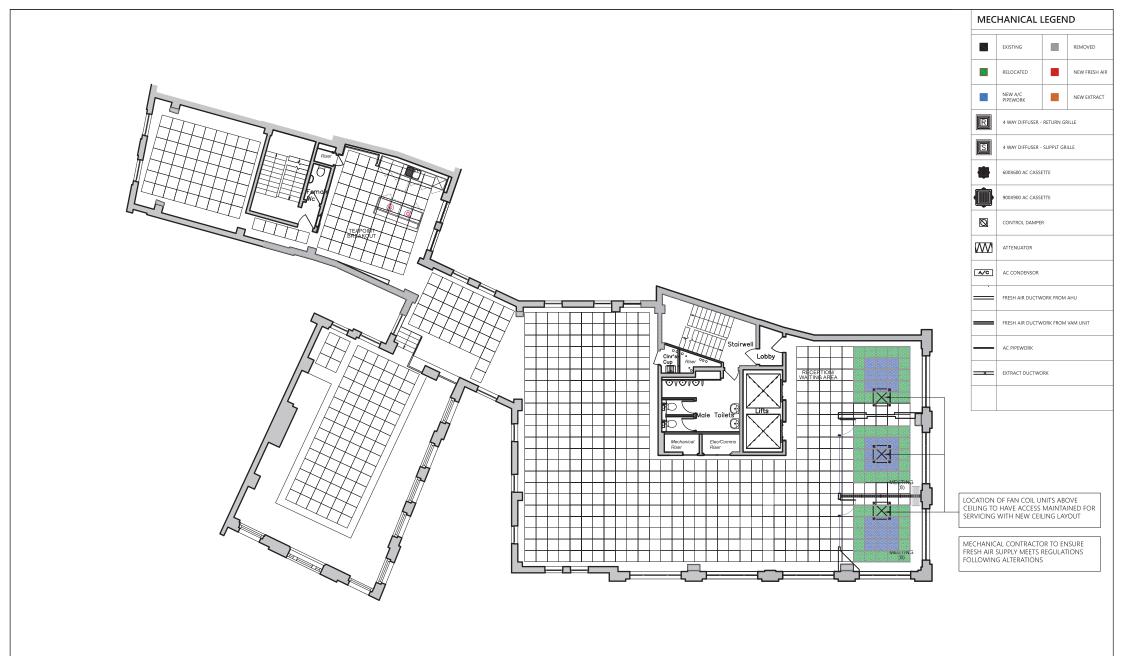

PROPOSED MECHANICAL SERVICES PLAN

CLIENT DRAWING TITLE

6NBS PROPOSED MECHANICAL PLAN

ADDRESS
FIRST FLOOR
6 NEW BRIDGE STREET
LONDON


PROJECT NUMBER DRAWING NUMBER RP2331 PR\_MS

SCALE DATE REVISION 1:100 @ A2 20.05.22 B

FOR INFORMATION



NOTE: DRAWING SUBJECT TO STATUTORY APPROVAL. DRAWING SHOULD NOT BE SCALED FROM: ALL DIMENSIONS SHOWN IN MM UNLESS OTHERWISE SHOWN.

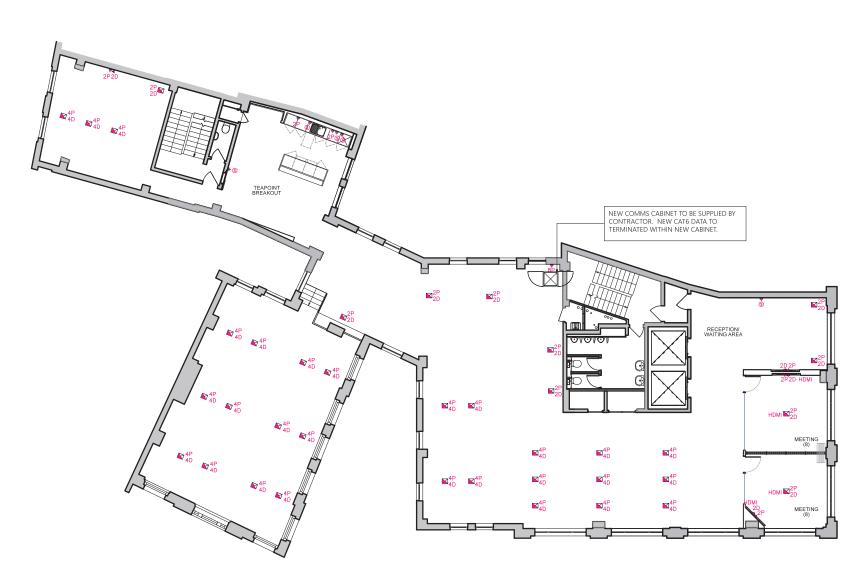

POWER & DATA LEGEND			
	EXISTING		REMOVED
	NEW		RELOCATED
4	POWER SOCKET		
×	DATA SOCKET		
	FLOOR BOX		
2P	POWER GANG QUANTITY		
2D	DATA POINT QUANTITY		
©	CLEANERS SOCKET		
S	FUSED SPUR		
H	HIGH LEVEL		

CLIENT DRAWING TITLE
6NBS PROPOSED ELECTRICAL & DATA

ADDRESS PROJECT NUMBER DRAWING NUMBER


 FIRST FLOOR
 RP2331
 PR\_ED


 6 NEW BRIDGE STREET
 SCALE
 DATE
 REVISION

 LONDON
 1:100 @ A2
 20.05.22
 B



FOR INFORMATION

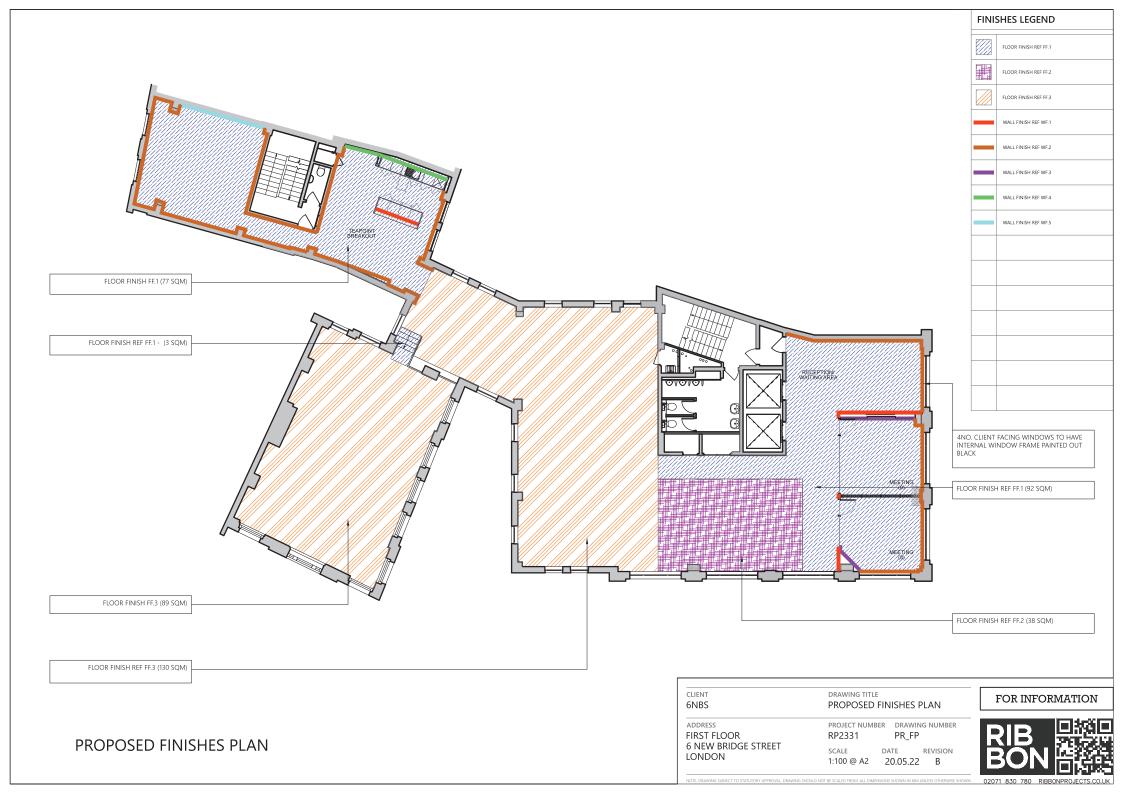

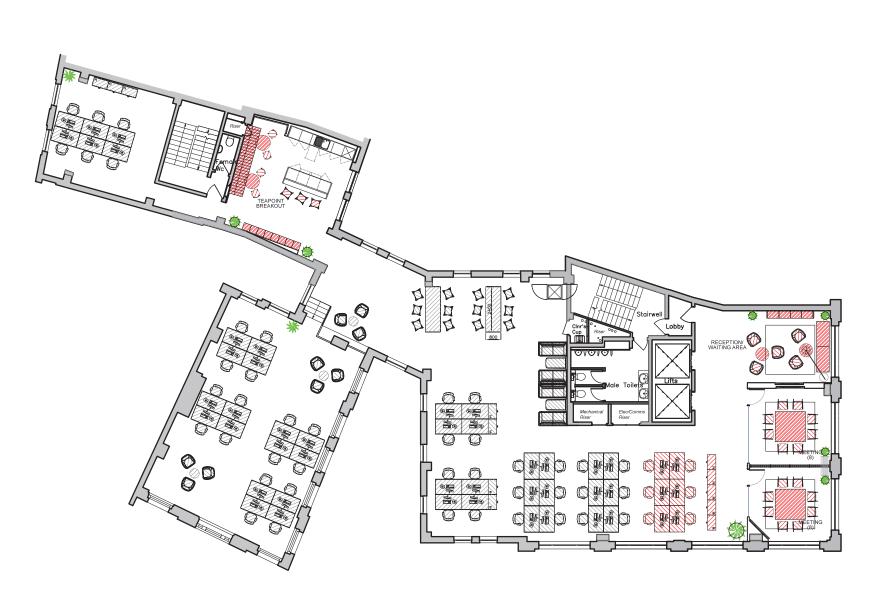

**FURNITURE LEGEND** DAY ONE FURNITURE FUTURE FURNITURE

CLIENT	DRAWING TITLE
6NBS	PROPOSED SPACE PLAN
ADDRECC	DROJECT NUMBER - DRAWING NUMBER

PROJECT NUMBER DRAWING NUMBER FIRST FLOOR 6 NEW BRIDGE STREET RP2331 PR\_SS DATE LONDON 1:100 @ A2 20.05.22 B

FOR INFORMATION

PROPOSED SPACE PLAN

